

<b>INTERMITTENT EXTRACT VENTILATION:</b> Kitchen = 30L/S Adjacent hob; Utility = 30L/S; Bathroom = 15L/S; En-Suites = 15L/S; Clk's = 6L/S
<b>PURGE VENTILATION:</b> All windows to habitable rooms to open more than 30 deg's, each habitable room to be provided with an operable window(s) with an opening area equal to 1/20th of the rooms floor area.
<b>STAIRCASE - GRD-1st</b>
13 equal risers of 209.38mm; Going = 234mm; Pitch 41.82°; Width over strings - 860mm

<b>ROOF VENTILATION (TYPE 1)</b>
An impermeable roofing underlay (Type 1F / HR) is to be draped over all roof pitches, with Rytons OFV1000 (or similar approved) over fascia ventilator providing ventilation equivalent to a continuous 10mm opening at eaves level, and Glidevale Fulmetal Redriol ventilated dry ridge system (or similar approved) providing ventilation equivalent to a continuous 5mm opening at ridge level.

GENERAL ARRANGEMENT PLANS - WALL LEGEND	
	Frost resistant quality facing brickwork 20N Brickwork laid in minimum class iii (M4) mortar.
	Medium dense blockwork to outer leaf behind tile hanging / cladding
	Compressive strength 7.3N/mm² minimum class iii (M4) mortar.
	Compressive strength 3.5N/mm² minimum class iii (M4) mortar.
Note: All external wall cavities to be 125mm unless otherwise specified.	
	70mm British Gypsum Gyprock 70SS0 'C' stud system, with studs at 600mm centres. 12.5mm Gyprock Soundbloc plasterboard each side with tapered edges, finished as per internal spec. Moisture-resistant plasterboard to bathroom with studs at 400mm centres.
	70mm Butressing Wall with 12mm Ply Sheathing as per SD/3022.
	12.5mm Gyprock Soundbloc plasterboard each side with tapered edges, finished as per internal spec. Moisture-resistant plasterboard to bathroom with studs at 400mm centres.
	63x38mm timber studs @ max 600mm centres. 50mm Isover acoustic partition roll (APR 1200) to be installed between studwork for the entire wall panel
	Movement Joints
	Denotes the position of the external cavity fire sock.
	Dashed line indicates extent of secondary DPC stepped up to accommodate level threshold to front door.
<b>IMPORTANT NOTE:</b> ALL EXTERNAL WALLS TO INCORPORATE BRICKFORCE SBF30W60 BED-JOINT REINFORCEMENT TO OUTER & INNER LEAF 2x COURSES ABOVE & BELOW ALL OPENINGS & TO PROJECT A MIN. 600mm BEYOND OPENING.	

ELECTRICAL KEY	
This electrical legend is to be read in conjunction with the internal specification & M&E consultants details if applicable with any discrepancies being reported to the site manager. Doorbells, light switches, entryphones, etc. should be fixed no higher than 1200mm above FFL. TV, BT & power sockets should be fixed no lower than 450mm above FFL. All wall lights to be fitted at 2100mm above FFL.	
Symbol	Description
	Flush double switch socket.
	Flush double switch socket with 2 USB points.
	External socket.
	13A flush unswitched spur.
Where switches are located all in the same wall, use 2/3/4 gang switches.	
Symbol	Description
	Flush double switched socket 200mm above kitchen work top with 2 USB points.
	Flush rocker light switch, 1,2 or 3 way switched.
	Ceiling rose light point.
	LED downlighter light fitting.
	Under-stair oval bulkhead wall mounted light.
	External Wall light.
	Batten holder light fitting.
	Door bell push.
	Door bell sounder.
Symbol	Description
	Flush double switched socket 200mm above kitchen work top.
	13A Flush unswitched outlet 300mm below kitchen work top.
	Flush 30A cooker switch 200mm above kitchen work top.
	Gas point.
	Shower head & control position.
	Ceiling mounted extract fan.
	Isolator switch.
	Shaver socket.


Symbol	Description
	Dual TV/ FM point 1xCT100 cabling (diplexer).
	Single slave phone socket 1xCAT 6 cabling.
	RJ45 data point
	HDMI port (4 & 5 beds only)
	Immersion heater switch, located in AC.
	Rad/Rail.
	Heating control programming switch.
	Grid switch.
	Thermostat.

Symbol	Description
	Carbon Monoxide Detector.
	Smoke Detector.
	Heat Detector.
	For sites with FTTP refer to SD/1002.
	For sites with FTTC refer to SD/1003.
	For full lounge plate specification refer to CALA Group Internal Specification.
	Intruder Alarm unit to Nacoss Standard
	Alarm Panel
For sites where virgin is to be provided, Virgin Media blanking plates are to be provided adjacent to the low level Lounge Plate in the lounge, and next to the TV/FM socket within the Family Room and Master Bedroom.	
	Pop up Socket for the Island
	External wall mounted Electric Meter
	British Telecom Point
	Hyper Optic Point
	Underfloor Heating Manifold


LOFT SPACE ELEC KEY	
Symbol	Description
	Batten holder light fitting.
	Flush double switch socket.
	Smoke Detector within loft space.
	Switch with Neon indicator

Notes  
All dimensions to be checked on site prior to the commencement of construction and any discrepancy should be reported to the Site Manager.  
This drawing may not be reproduced in any part or form without written consent.  
All copyrights reserved.  
Sub-Contractors MUST ensure that they have the latest issue drawing before they commence work on site.

This drawing is to be read in conjunction with all relevant Specifications, schedules and Engineers details.

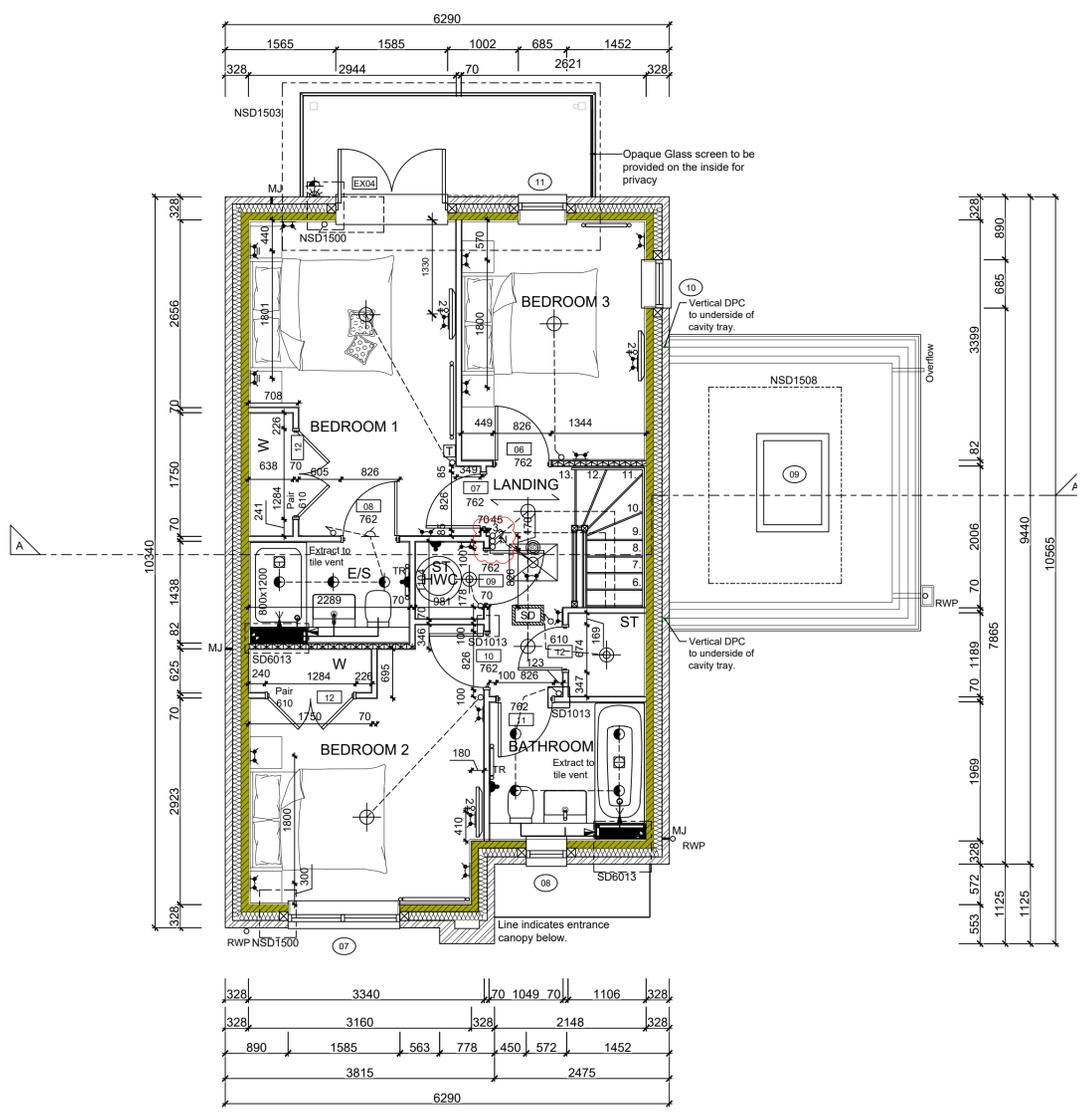

**FIRST FLOOR LAYOUT**  
SCALE 1:50

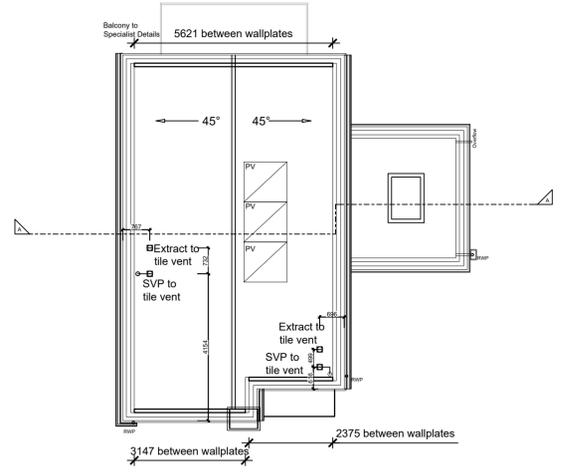

**ROOF LAYOUT**  
SCALE 1:100

Rev	Date	Description	Int.
N	10.01.26	Switch added	ZJ
M	17.11.25	Dimensions added/adjusted. Store size updated to allow for 100mm door ribs. Doors re-positioned. Thermostat relocated to bed 1.	CL
L	18.07.25	Thermostat relocated. TV moved dims added. Basin updated as per spec. Sanitary ware amended as per spec. Stair amended. Builders wardrobe added to Bed2. TV centered to wall	SK
K	27.01.25	SD added to Loft hatch. SD legend added. PV panels added to roof plan.	SK
J	20.01.25	M&E coordinated. Sockets coordinated	DF



Job title  
**Brooklands College  
Weybridge**

Drawing title  
**House Type HT7  
3B5P Plots: 188  
First Floor &  
Roof Plan**

Scale 1:50/1:100 @ A1 Date May 2023

Rev. N Drawn JM

Dwg No.  
SA00394-0057-A-HT7-GA